



**U.S. Army Corps
of Engineers
Afghanistan Engineer District**

**ANP UP Provincial HQ
And PRC #1**

Kandahar, Afghanistan

Appendix A

Concept Site Plans



UNIFORM POLICE PROVINCIAL HEADQUARTERS

FACILITY	STANDARD DESIGNATION	APPROXIMATE SIZE (GSM)
100A	ADMINISTRATION BUILDING, FIRST FLOOR	AD13 1446/2
100B	ADMINISTRATION BUILDING, SECOND FLOOR	AD13 1446/2
101	DINING FACILITY	D07 (TYPE 2) 559
102	TRAINING BUILDING	CL06 319
103	BARRACKS BUILDING	CL06 319
104A	SENIOR BARRACKS BUILDING, FIRST FLOOR	B12 862/2
104B	SENIOR BARRACKS BUILDING, SECOND FLOOR	B12 862/2
105	LATRINE BUILDING	L02 (MEDIUM) 180
106	WOMEN'S BARRACKS	B25 (MEDIUM) 280
107	DETENTION CELL BUILDING	MS04 180
108	GUARD TOWER	FP04A 12
109	GUARD HOUSE	FP07 54
110	GUARD SHACK	FP05 12
111	TRASH COLLECTION POINT	G01 -
112	WELL HOUSE WITH WELL	U03 20
113	20-METER WATER TOWER	U05 -
114	FUEL STORAGE AND REFUELING POINT	U02 -
115	VEHICLE MAINTENANCE FACILITY WITH POL BUILDING	VM05 206
116	WAREHOUSE BUILDING	S06 (SMALL) 65
117	SECURE STORAGE	S07 90
118	FRU OFFICES	AD20 60
119	TOILET BUILDING	- -
120	SEPTIC HOLDING TANK	- -
121	LEACH FIELD (OPTION)	- -

PROVINCIAL RESPONSE COMPANY #1

FACILITY	STANDARD DESIGNATION	APPROXIMATE SIZE (GSM)
200	ADMINISTRATION BUILDING	AD16 (TYPE 5) 508
201	OPEN BAY BARRACKS	B13 (TYPE 2) 579
202	SENIOR/HIGH BARRACKS	B14 (TYPE 3) 384
203	FEMALE BARRACKS	B26 (SMALL) 48
204	DINING FACILITY	D08 (TYPE 3) 384
205	GUARD HOUSE	FP07 50
206	GUARD SHACK	FP05 12
207	GUARD TOWER	FP04A 12
208	TRASH COLLECTION POINT	G01 -
209	LATRINE BUILDING	L02 (MEDIUM) 180
210	WAREHOUSE BUILDING	S06 (SMALL) 65
211	SECURE STORAGE	S07 90
212	WELL HOUSE WITH WELL	U03 20
213	20-METER WALL TOWER	U05 -
214	FUEL STORAGE AND REFUELING POINT	U02 -
215	POL STORAGE BUILDING	VM06 25
216	SEPTIC HOLDING TANK	- -
217	LEACH FIELD (OPTION)	- -

NOT FOR CONSTRUCTION



LEGEND

ADMINISTRATION	CAR PARKING	CLOTHESLINE
BARRACKS	TRUCK PARKING	TRAILER PARKING
TRAINING	ROADS	SIDE WALK
CID/FRU	STAND OFF	FORCE PROTECTION WALL
DFAC	CHAIN LINK FENCE	SWING-ARM GATE
ASP		
SECURITY		
SUPPORT		
CONCRETE BARRIER		

CONCEPT SITE PLAN



LOCATION MAP



SCALE: AS SHOWN

DATE: May, 26, 2010

FIGURE: P2-3UR-PRD-Gen-01-CAMP

AFGHAN NATIONAL SECURITY FORCE
Comprehensive Plan for Facilities Development

UNIFORM POLICE PROVINCIAL HEADQUARTERS
AND PROVINCIAL RESPONSE COMPANY #1
KANDAHAR

REVISION: 1


DESIGN: _____

DRAWN: _____

CHECKED: _____

IN CHARGE: _____

PROJECT: _____

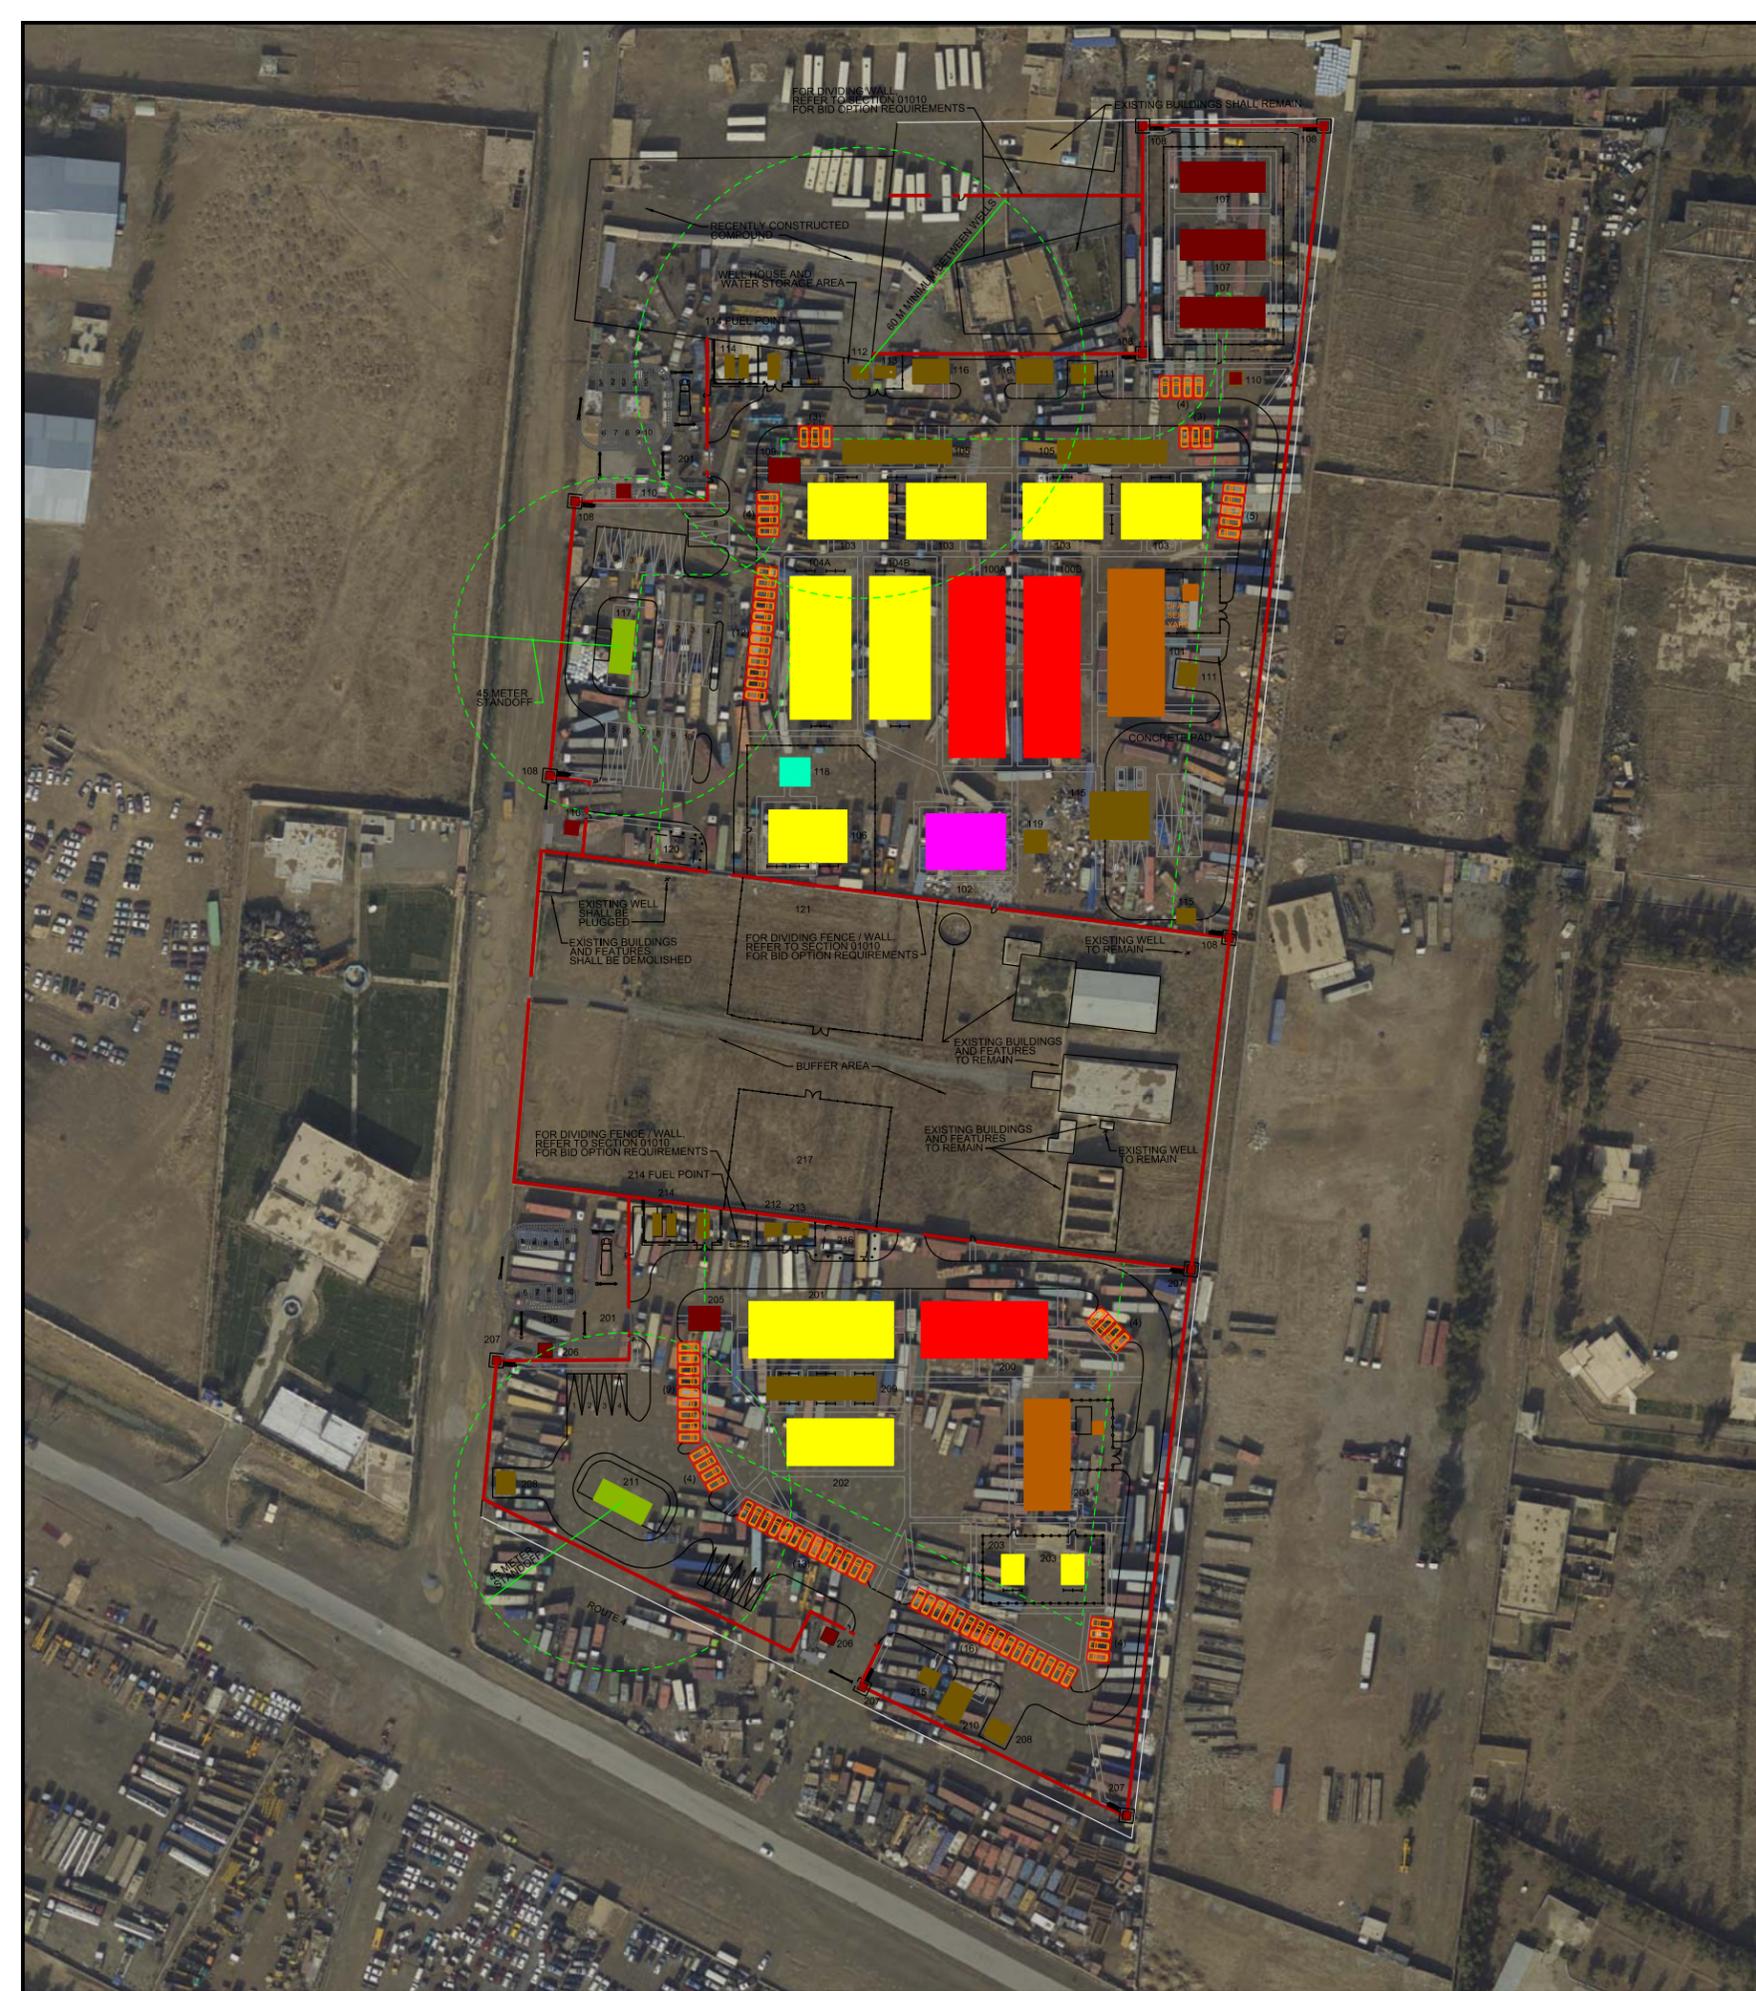

UNIFORM POLICE PROVINCIAL HEADQUARTERS

FACILITY	STANDARD DESIGNATION	APPROXIMATE SIZE (GSM)
100A	ADMINISTRATION BUILDING, FIRST FLOOR	AD13 1446/2
100B	ADMINISTRATION BUILDING, SECOND FLOOR	AD13 1446/2
101	DINING FACILITY	D07 (TYPE 2) 559
102	TRAINING BUILDING	CL06 319
103	BARRACKS BUILDING	CL06 319
104A	SENIOR BARRACKS BUILDING, FIRST FLOOR	B12 862/2
104B	SENIOR BARRACKS BUILDING, SECOND FLOOR	B12 862/2
105	LATRINE BUILDING	L02 (MEDIUM) 180
106	WOMEN'S BARRACKS	B25 (MEDIUM) 280
107	DETENTION CELL BUILDING	MS04 180
108	GUARD TOWER	FP04A 12
109	GUARD HOUSE	FP07 54
110	GUARD SHACK	FP05 12
111	TRASH COLLECTION POINT	G01 -
112	WELL HOUSE WITH WELL	U03 20
113	20-METER WATER TOWER	U05 -
114	FUEL STORAGE AND REFUELING POINT	U02 -
115	VEHICLE MAINTENANCE FACILITY WITH POL BUILDING	VM05 206
116	WAREHOUSE BUILDING	S06 (SMALL) 65
117	SECURE STORAGE	S07 90
118	FRU OFFICES	AD20 60
119	TOILET BUILDING	- -
120	SEPTIC HOLDING TANK	- -
121	LEACH FIELD (OPTION)	- -

PROVINCIAL RESPONSE COMPANY #1

FACILITY	STANDARD DESIGNATION	APPROXIMATE SIZE (GSM)
200	ADMINISTRATION BUILDING	AD16 (TYPE 5) 508
201	OPEN BAY BARRACKS	B13 (TYPE 2) 579
202	SENIOR/HIGH BARRACKS	B14 (TYPE 3) 384
203	FEMALE BARRACKS	B26 (SMALL) 48
204	DINING FACILITY	D08 (TYPE 3) 384
205	GUARD HOUSE	FP07 50
206	GUARD SHACK	FP05 12
207	GUARD TOWER	FP04A 12
208	TRASH COLLECTION POINT	G01 -
209	LATRINE BUILDING	L02 (MEDIUM) 180
210	WAREHOUSE BUILDING	S06 (SMALL) 65
211	SECURE STORAGE	S07 90
212	WELL HOUSE WITH WELL	U03 20
213	20-METER WALL TOWER	U05 -
214	FUEL STORAGE AND REFUELING POINT	U02 -
215	POL STORAGE BUILDING	VM06 25
216	SEPTIC HOLDING TANK	- -
217	LEACH FIELD (OPTION)	- -

NOT FOR CONSTRUCTION

LEGEND

	ADMINISTRATION		CLOTHESLINE
	BARRACKS		CAR PARKING
	TRAINING		TRUCK PARKING
	CID/FRU		TRAILER PARKING
	DFAC		ROADS
	ASP		SIDE WALK
	SECURITY		STAND OFF
	SUPPORT		FORCE PROTECTION WALL
	CONCRETE BARRIER		CHAIN LINK FENCE
			SWING-ARM GATE

LOCATION MAP



CONCEPT SITE PLAN



SCALE : AS SHOWN	DATE: May, 26, 2010	FIGURE P2.3-UP-PHC-Genet&MP
AFGHAN NATIONAL SECURITY FORCE Comprehensive Plan for Facilities Development		
UNIFORM POLICE PROVINCIAL HEADQUARTERS AND PROVINCIAL RESPONSE COMPANY #1 KANDAHAR		
REVISION : 1	DESIGN :	DRAWN :
	CHECKED :	IN CHARGE :
		PROJECT :

FOR DIVIDING WALL,
REFER TO SECTION 01010
FOR BID OPTION REQUIREMENTS

EXISTING BUILDINGS SHALL REMAIN



UNIFORM POLICE PROVINCIAL HEADQUARTERS

FACILITY	STANDARD DESIGNATION	APPROXIMATE SIZE (GSM)
100A	ADMINISTRATION BUILDING, FIRST FLOOR	AD13 1446/2
100B	ADMINISTRATION BUILDING, SECOND FLOOR	AD13 1446/2
101	DINING FACILITY	D07 (TYPE 2) 559
102	TRAINING BUILDING	CL06 319
103	BARRACKS BUILDING	CL06 319
104A	SENIOR BARRACKS BUILDING, FIRST FLOOR	B12 862/2
104B	SENIOR BARRACKS BUILDING, SECOND FLOOR	B12 862/2
105	LATRINE BUILDING	L02 (MEDIUM) 180
106	WOMEN'S BARRACKS	B25 (MEDIUM) 280
107	DETENTION CELL BUILDING	MS04 180
108	GUARD TOWER	FP04A 12
109	GUARD HOUSE	FP07 54
110	GUARD SHACK	FP05 12
111	TRASH COLLECTION POINT	G01 -
112	WELL HOUSE WITH WELL	U03 20
113	20-METER WATER TOWER	U05 -
114	FUEL STORAGE AND REFUELING POINT	U02 -
115	VEHICLE MAINTENANCE FACILITY WITH POL BUILDING	VM05 206
116	WAREHOUSE BUILDING	S06 (SMALL) 65
117	SECURE STORAGE	S07 90
118	FRU OFFICES	AD20 60
119	TOILET BUILDING	- -
120	SEPTIC HOLDING TANK	- -
121	LEACH FIELD (OPTION)	- -

NOT FOR CONSTRUCTION

LEGEND

	ADMINISTRATION		CLOTHESLINE
	BARRACKS		CAR PARKING
	TRAINING		TRUCK PARKING
	CID/FRU		TRAILER PARKING
	DFAC		ROADS
	ASP		SIDE WALK
	SECURITY		STAND OFF
	SUPPORT		FORCE PROTECTION WALL
	CONCRETE BARRIER		CHAIN LINK FENCE
	BARRIER		SWING-ARM GATE



CONCEPT SITE PLAN
UP PROVINCIAL HQ



LOCATION MAP



SCALE: AS SHOWN

DATE: May, 26, 2010

FIGURE: P2-3-UP-PHQ-ConceptSMP

AFGHAN NATIONAL SECURITY FORCE
Comprehensive Plan for Facilities Development

UNIFORM POLICE PROVINCIAL HEADQUARTERS
AND PROVINCIAL RESPONSE COMPANY #1
KANDAHAR

REVISION: 1


DESIGN: _____

DRAWN: _____

CHECKED: _____

IN CHARGE: _____

PROJECT: _____

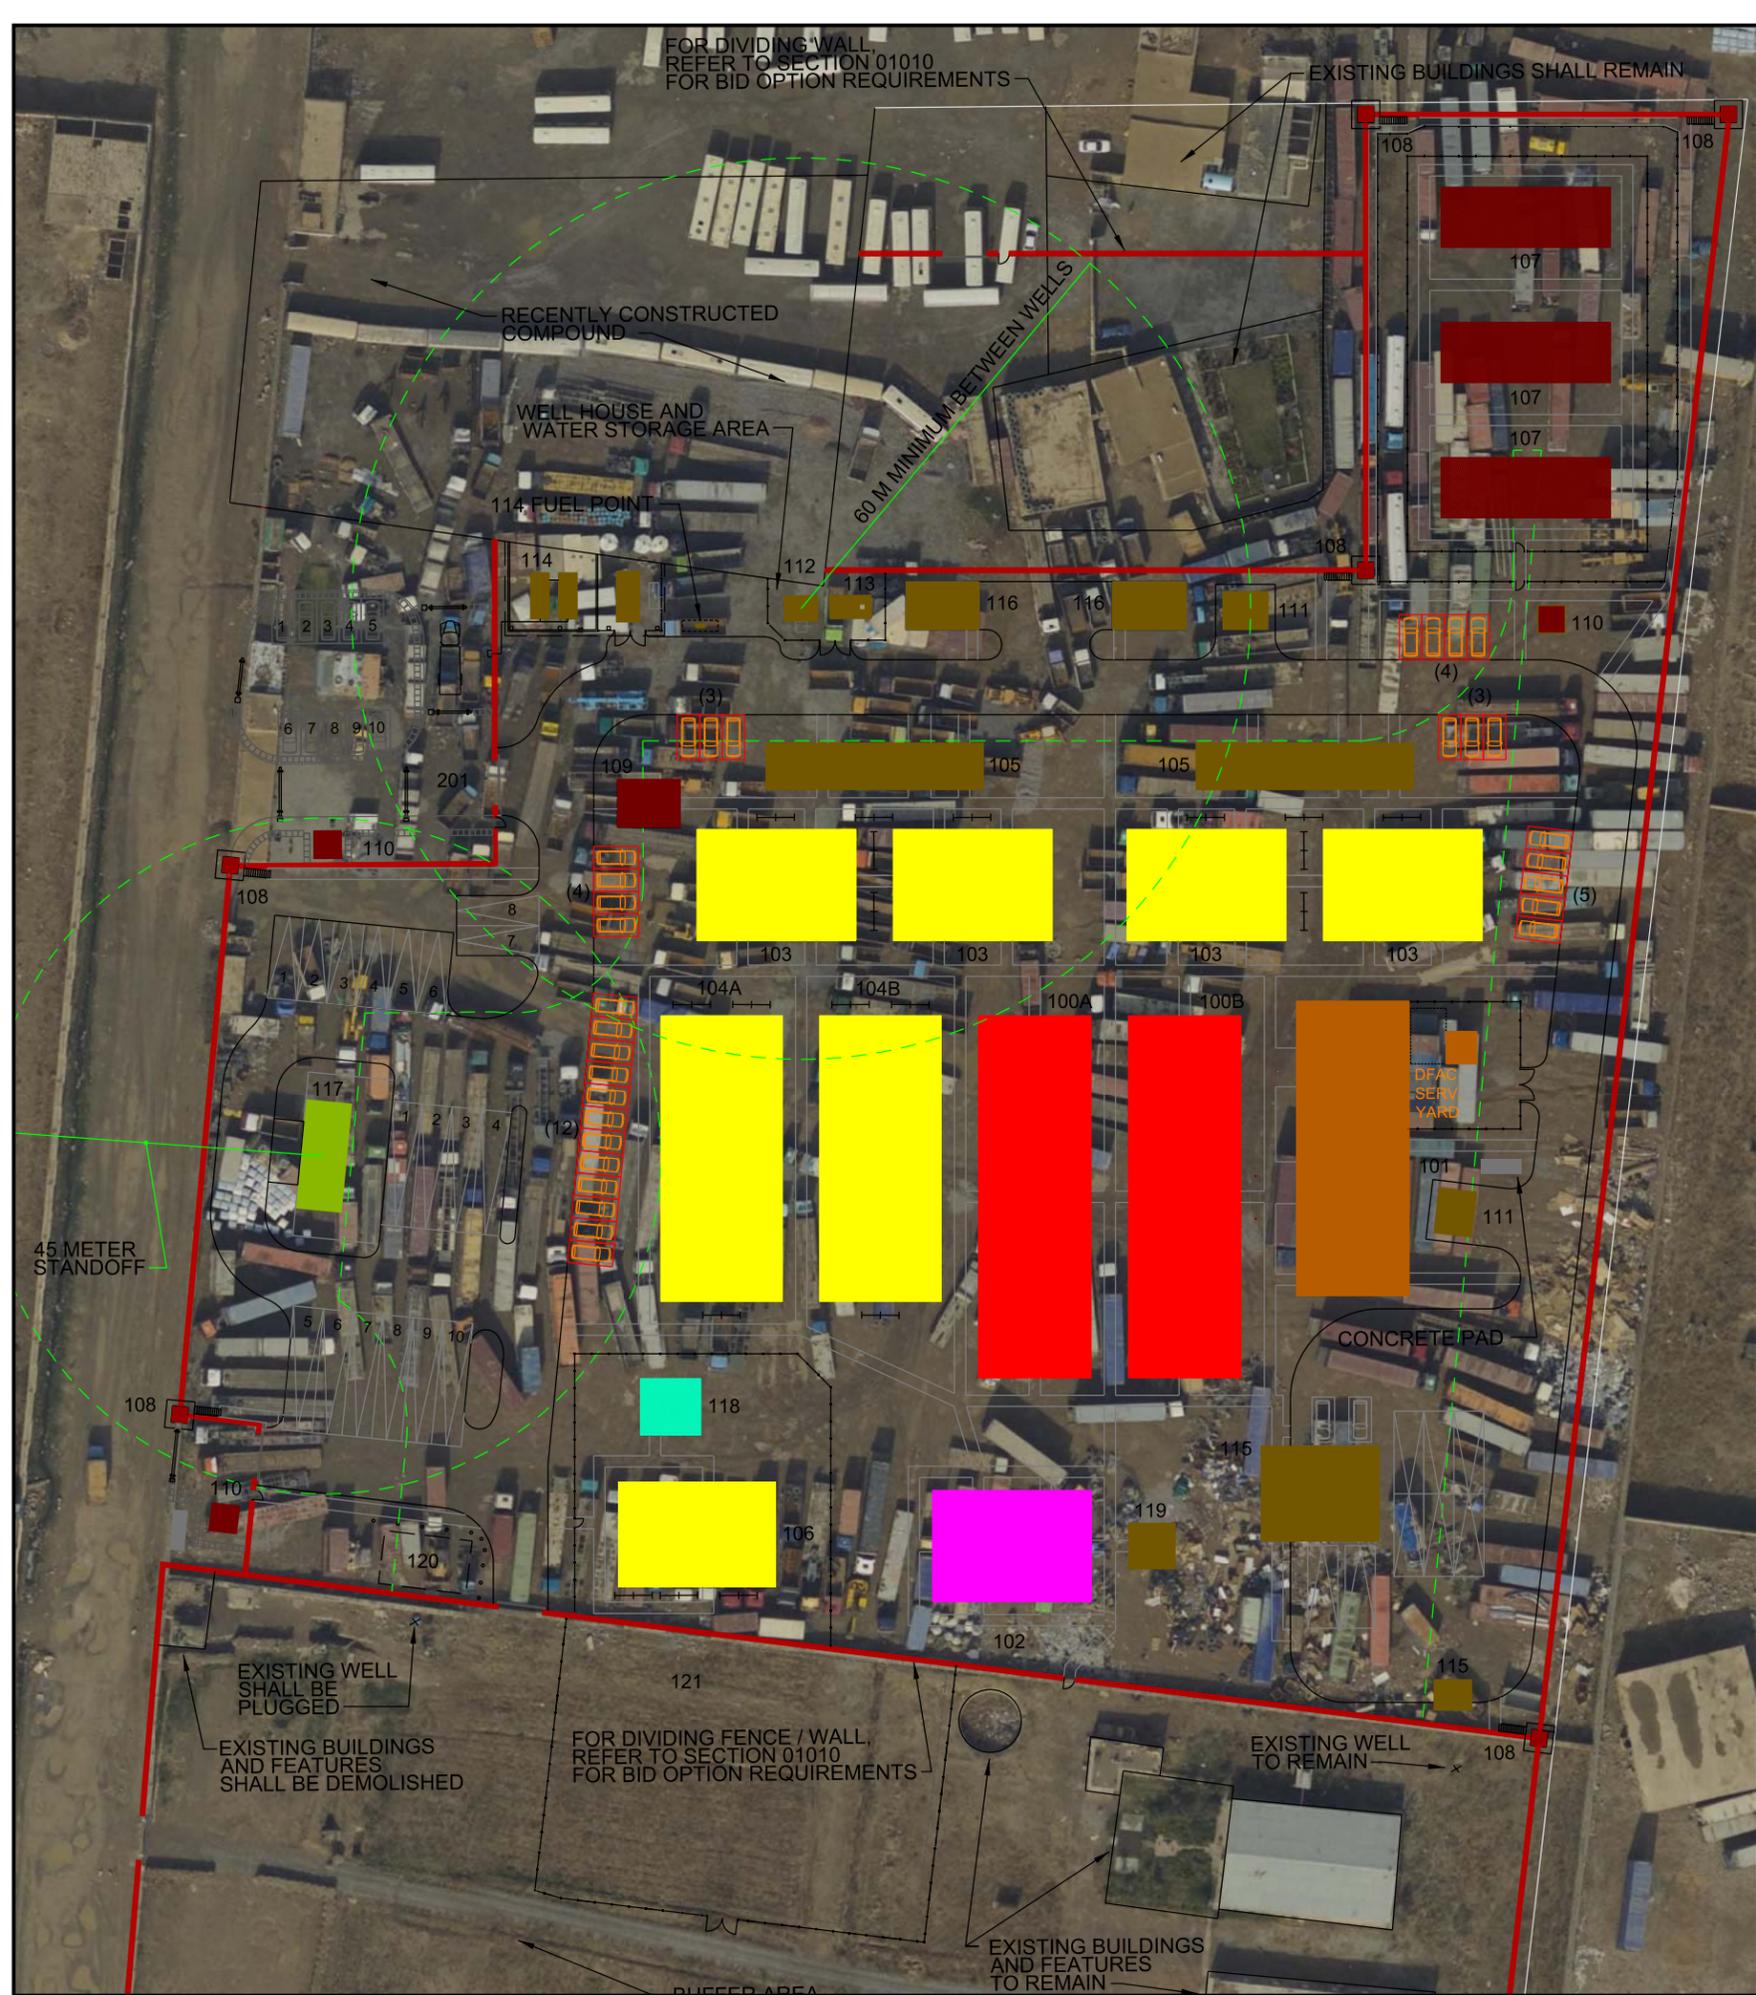

UNIFORM POLICE PROVINCIAL HEADQUARTERS


FACILITY	STANDARD DESIGNATION	APPROXIMATE SIZE (GSM)
100A	ADMINISTRATION BUILDING, FIRST FLOOR	AD13 1446/2
100B	ADMINISTRATION BUILDING, SECOND FLOOR	AD13 1446/2
101	DINING FACILITY	D07 (TYPE 2) 559
102	TRAINING BUILDING	CL06 319
103	BARRACKS BUILDING	CL06 319
104A	SENIOR BARRACKS BUILDING, FIRST FLOOR	B12 862/2
104B	SENIOR BARRACKS BUILDING, SECOND FLOOR	B12 862/2
105	LATRINE BUILDING	L02 (MEDIUM) 180
106	WOMEN'S BARRACKS	B25 (MEDIUM) 280
107	DETENTION CELL BUILDING	MS04 180
108	GUARD TOWER	FP04A 12
109	GUARD HOUSE	FP07 54
110	GUARD SHACK	FP05 12
111	TRASH COLLECTION POINT	G01 -
112	WELL HOUSE WITH WELL	U03 20
113	20-METER WATER TOWER	U05 -
114	FUEL STORAGE AND REFUELING POINT	U02 -
115	VEHICLE MAINTENANCE FACILITY WITH POL BUILDING	VM05 206
116	WAREHOUSE BUILDING	S06 (SMALL) 65
117	SECURE STORAGE	S07 90
118	FRU OFFICES	AD20 60
119	TOILET BUILDING	-
120	SEPTIC HOLDING TANK	-
121	LEACH FIELD (OPTION)	-

NOT FOR CONSTRUCTION

LEGEND

	ADMINISTRATION		CLOTHESLINE
	BARRACKS		CAR PARKING
	TRAINING		TRUCK PARKING
	CID/FRU		TRAILER PARKING
	DFAC		ROADS
	ASP		SIDE WALK
	SECURITY		STAND OFF
	SUPPORT		FORCE PROTECTION WALL
	CONCRETE BARRIER		CHAIN LINK FENCE
			SWING-ARM GATE

 
CONCEPT SITE PLAN UP PROVINCIAL HQ



LOCATION MAP



SCALE: AS SHOWN	DATE: May, 26, 2010	FIGURE: P23-UP-PRO-Gen-05-01
AFGHAN NATIONAL SECURITY FORCE Comprehensive Plan for Facilities Development		UNIFORM POLICE PROVINCIAL HEADQUARTERS AND PROVINCIAL RESPONSE COMPANY #1 KANDAHAR
REVISION: 1	DESIGN:	CHECKED:
	DRAWN:	IN CHARGE:
		PROJECT:

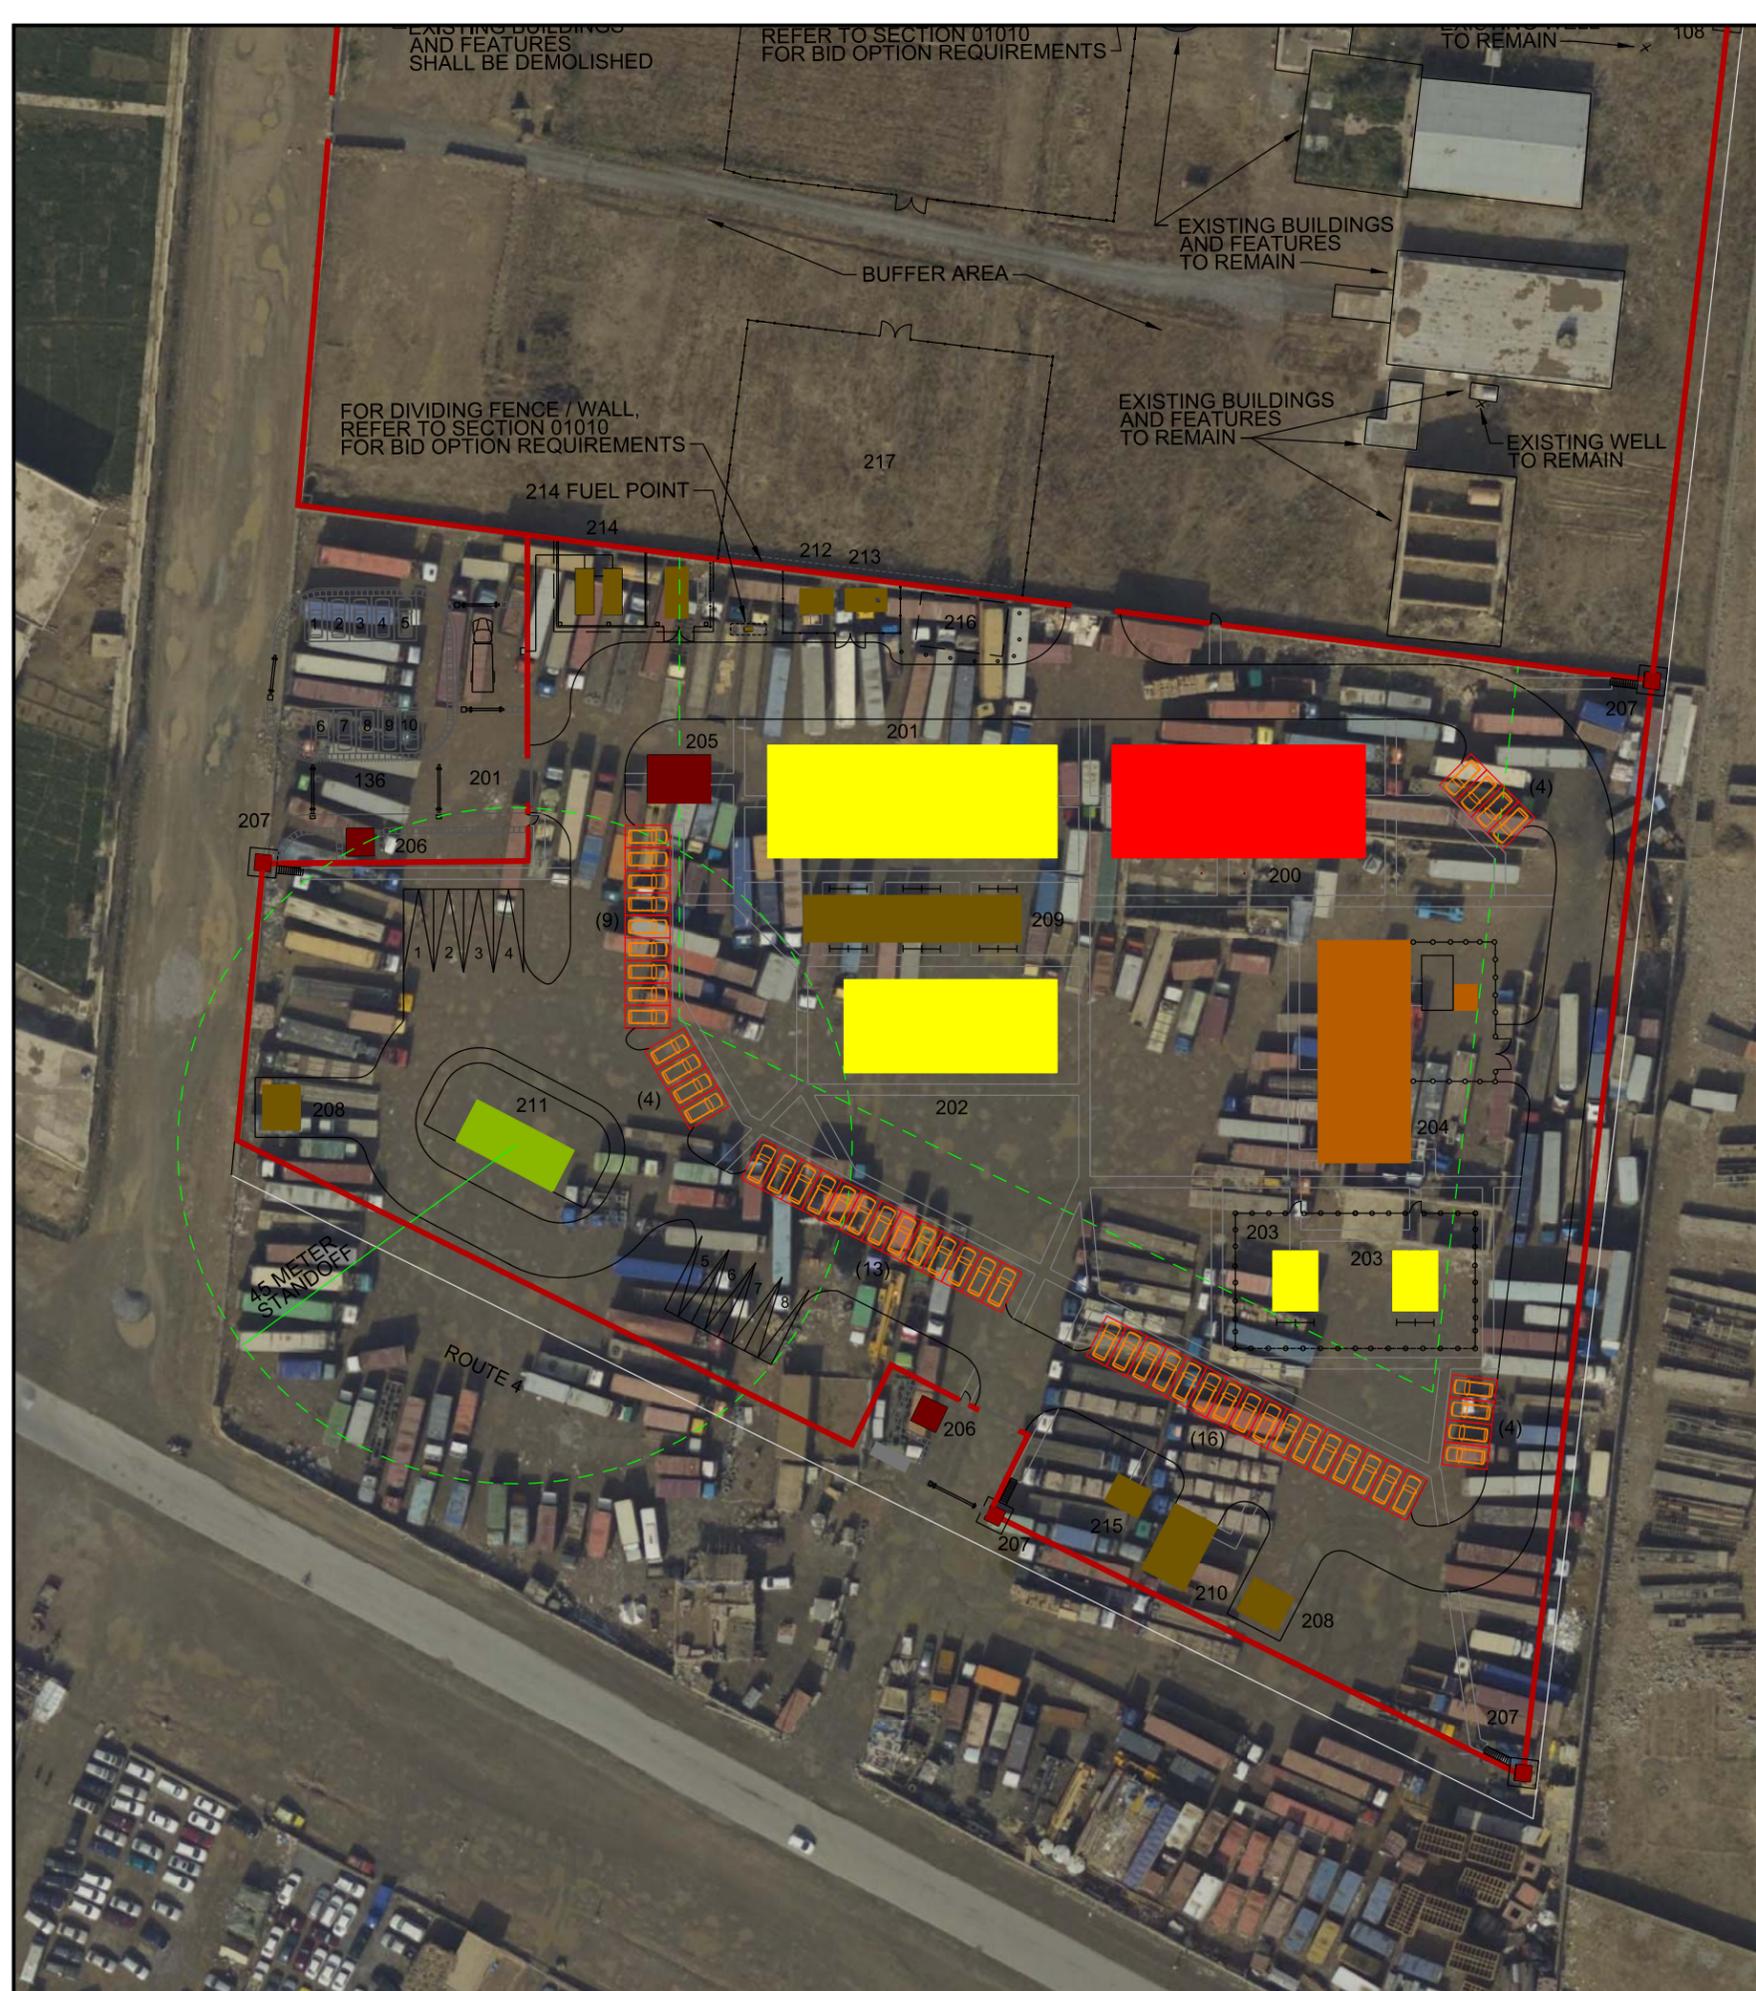

PROVINCIAL RESPONSE COMPANY #1

FACILITY	STANDARD DESIGNATION	APPROXIMATE SIZE (GSM)
200	AD16 (TYPE 5)	508
201	B13 (TYPE 2)	579
202	B14 (TYPE 3)	384
203	B26 (SMALL)	48
204	D08 (TYPE 3)	384
205	FP07	50
206	FP05	12
207	FP04A	12
208	G01	-
209	L02 (MEDIUM)	180
210	S06 (SMALL)	65
211	S07	90
212	U03	20
213	U05	-
214	U02	-
215	VM06	25
216	-	-
217	-	-

NOT FOR CONSTRUCTION


LEGEND

	ADMINISTRATON		CAR PARKING
	BARRACKS		TRUCK PARKING
	TRAINING		TRAILER PARKING
	CID/FRU		ROADS
	DFAC		SIDE WALK
	ASP		STAND OFF
	SECURITY		FORCE PROTECTION WALL
	SUPPORT		CHAIN LINK FENCE
	CONCRETE BARRIER		SWING-ARM GATE
			CLOTHESLINE

LOCATION MAP



 **CONCEPT SITE PLAN
PRC #1**



SCALE: AS SHOWN	DATE: May, 26, 2010	FIGURE: P23-PRC-Concepts/PR
AFGHAN NATIONAL SECURITY FORCE Comprehensive Plan for Facilities Development		
UNIFORM POLICE PROVINCIAL HEADQUARTERS AND PROVINCIAL RESPONSE COMPANY #1 KANDAHAR		
REVISION: 1	DESIGN:	CHECKED:
	DRAWN:	IN CHARGE:
		PROJECT: